


NUMBER  
**RP A2 9 PlankClip Alu**  
 BOARD - SUB-CONSTRUCTION  
 A2 9 mm - PlankClip on aluminium  
 SECTION - DETAIL  
 Front Page - Overview  
 DESCRIPTION  
 Details overview

DATE - VERSION  
 01.07.2025  
 SCALE - PAPER  
 Scale 1:20 on A3 print

LANGUAGE  
 All  
 PAGE - NUMBER  
 Page 01/10



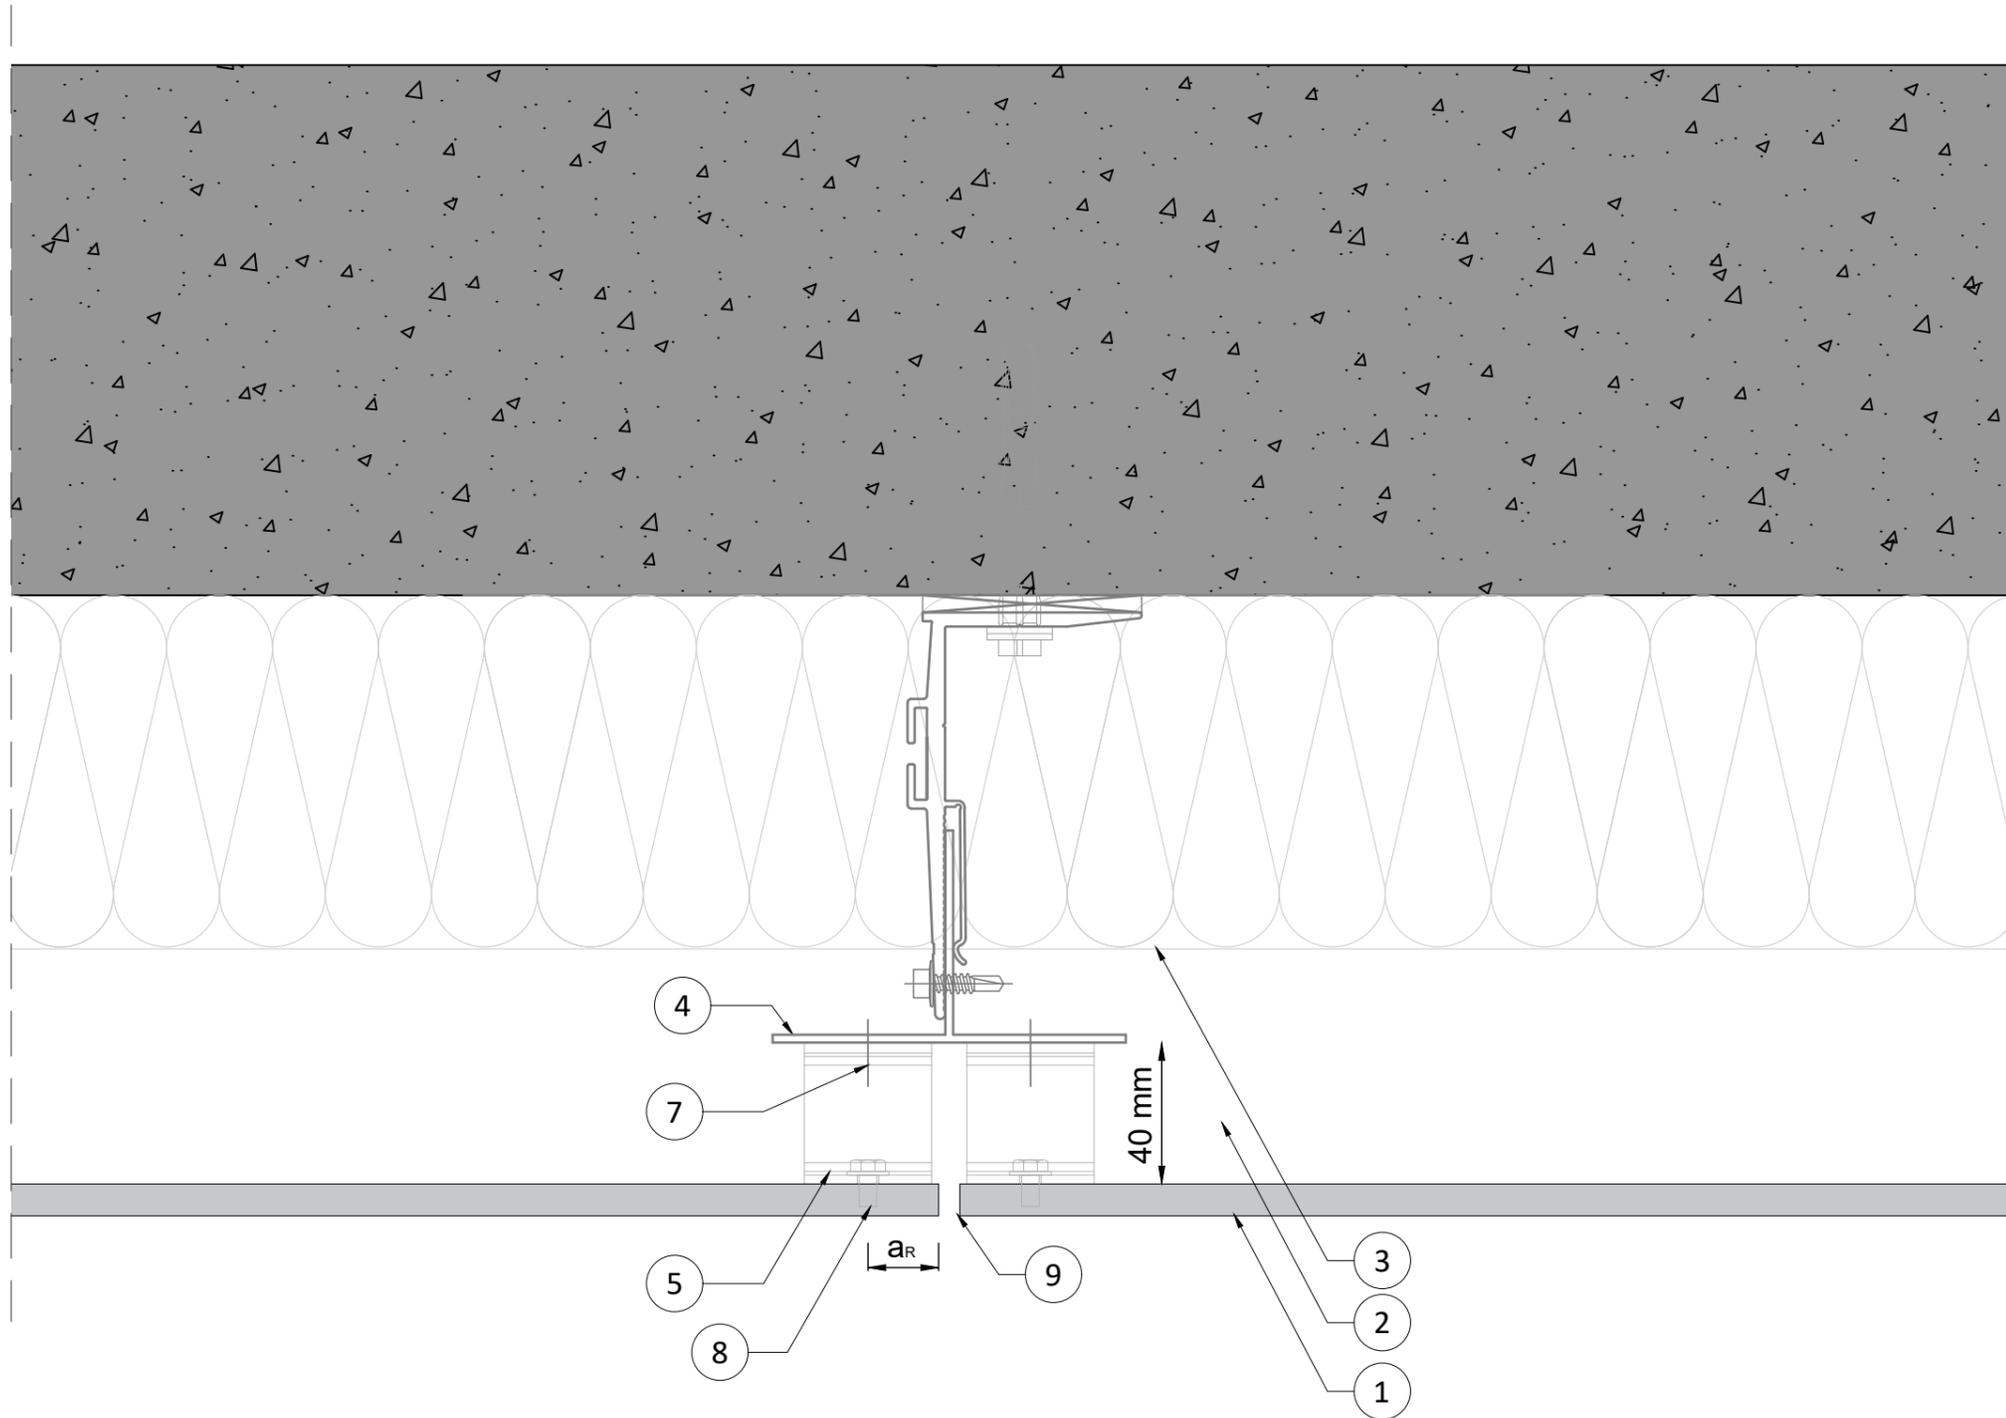

NUMBER  
**RP A2 9 PlankClip Alu**

BOARD - SUB-CONSTRUCTION  
 A2 9 mm - PlankClip on aluminium

SECTION - DETAIL  
 Horizontal section - Detail 01


DESCRIPTION  
 Junction vertical joint

DATE - VERSION  
 01.07.2025

SCALE - PAPER  
 Scale 1:2 on A3 print

LANGUAGE  
 All

PAGE - NUMBER  
 Page 02/10

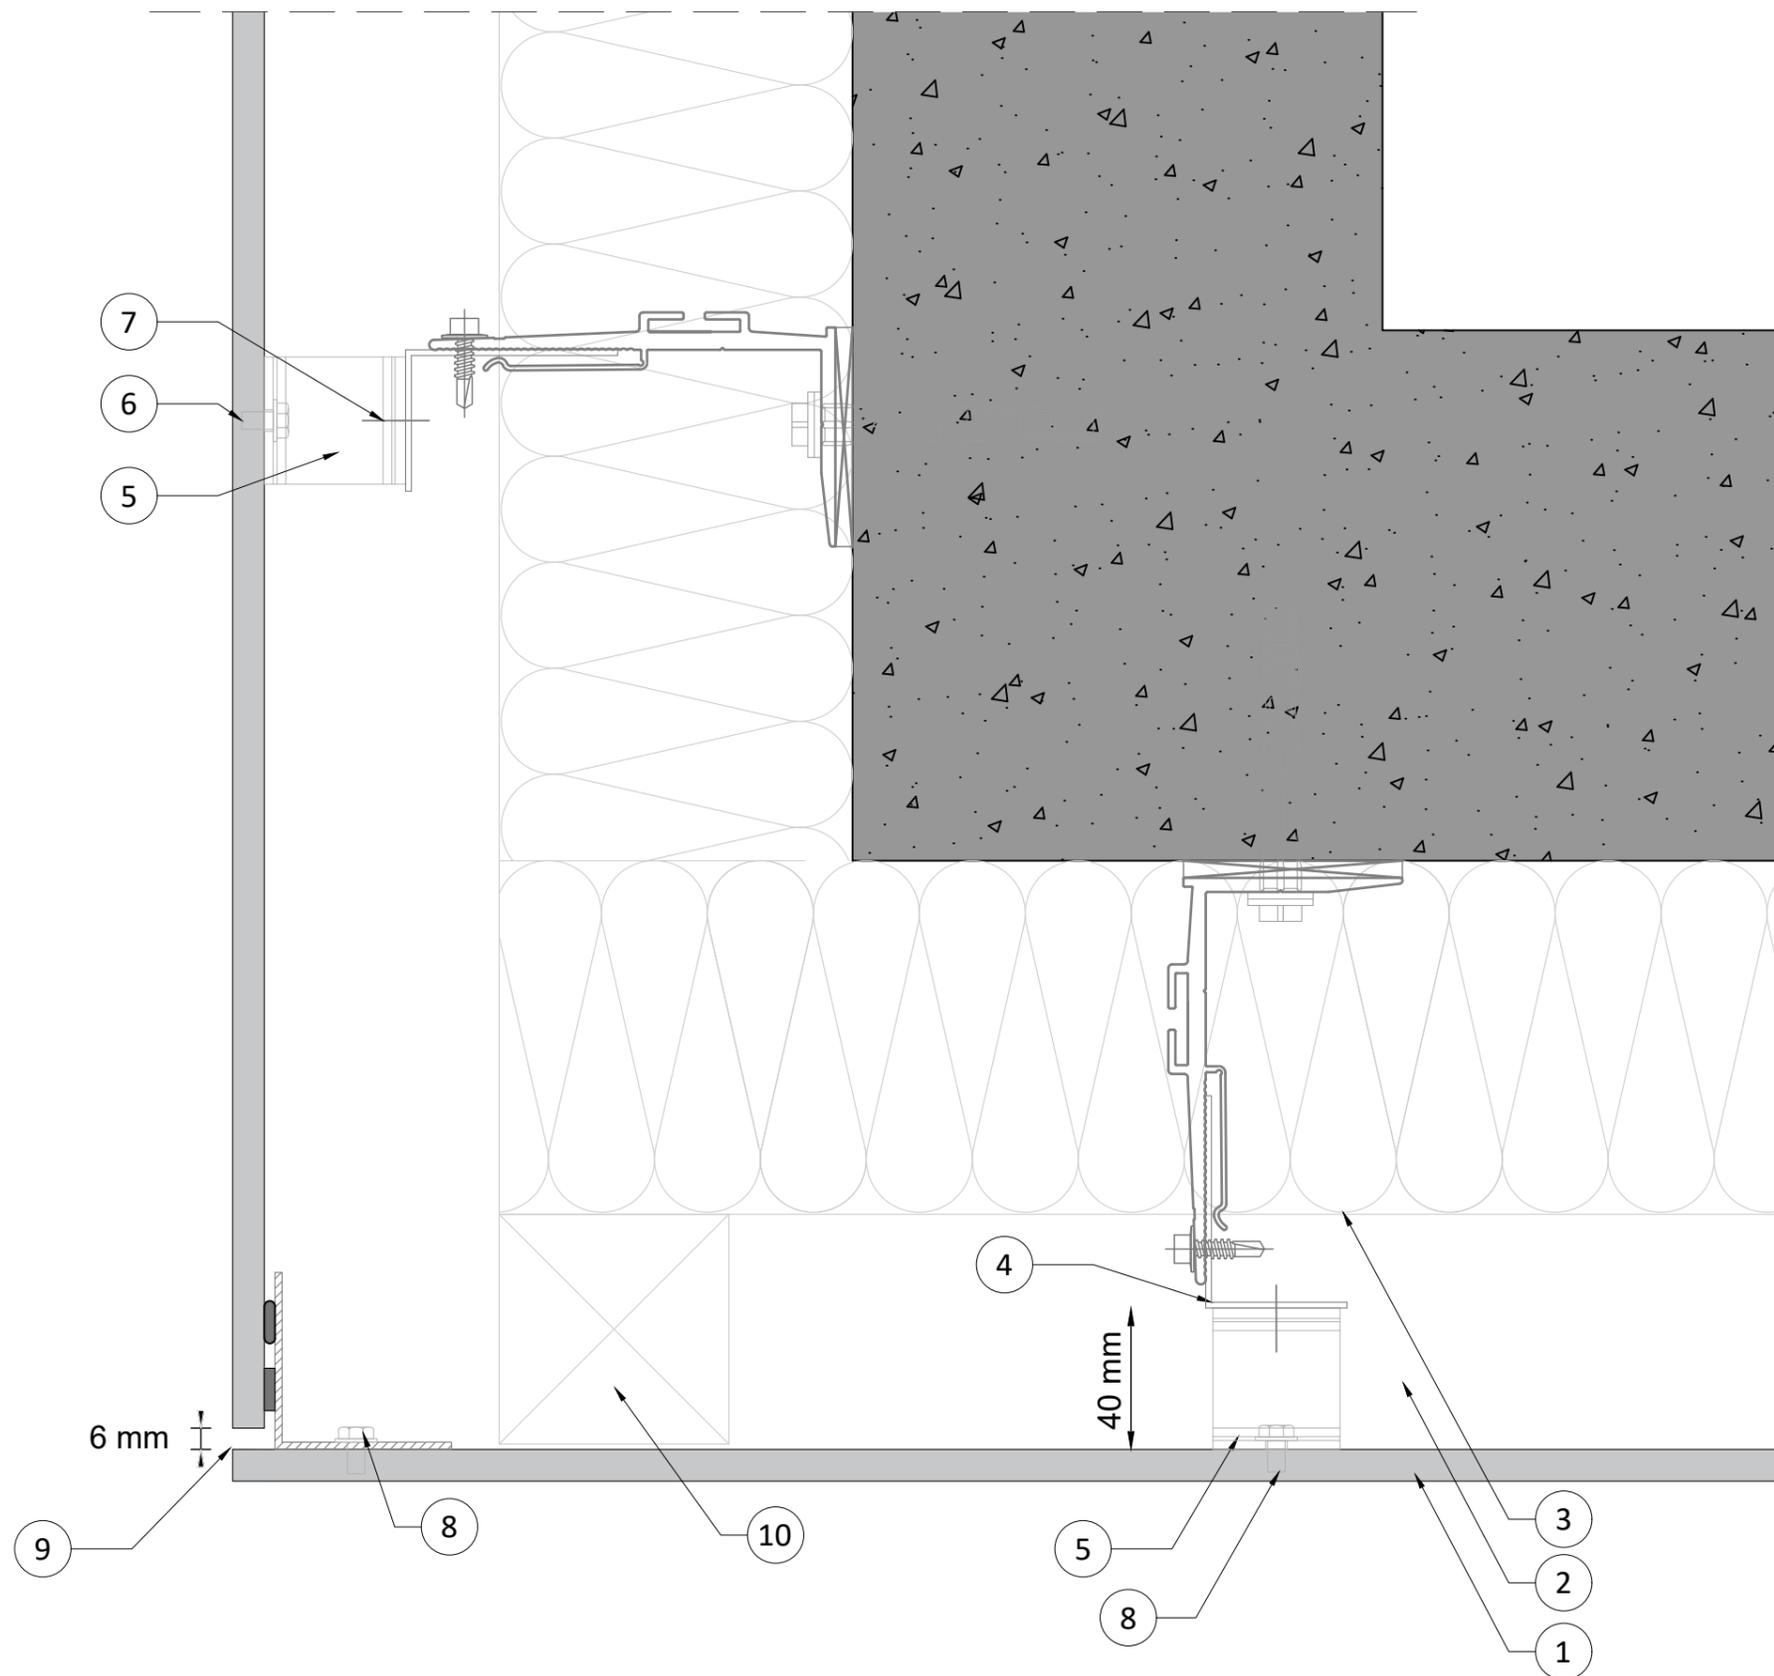

NUMBER  
**RP A2 9 PlankClip Alu**


BOARD - SUB-CONSTRUCTION  
**A2 9 mm - PlankClip on aluminium**  
 SECTION - DETAIL  
**Horizontal section - Detail 02**  
 DESCRIPTION  
**Junction vertical joint**

DATE - VERSION  
 01.07.2025  
 SCALE - PAPER  
 Scale 1:2 on A3 print

LANGUAGE  
 All  
 PAGE - NUMBER  
 Page 03/10





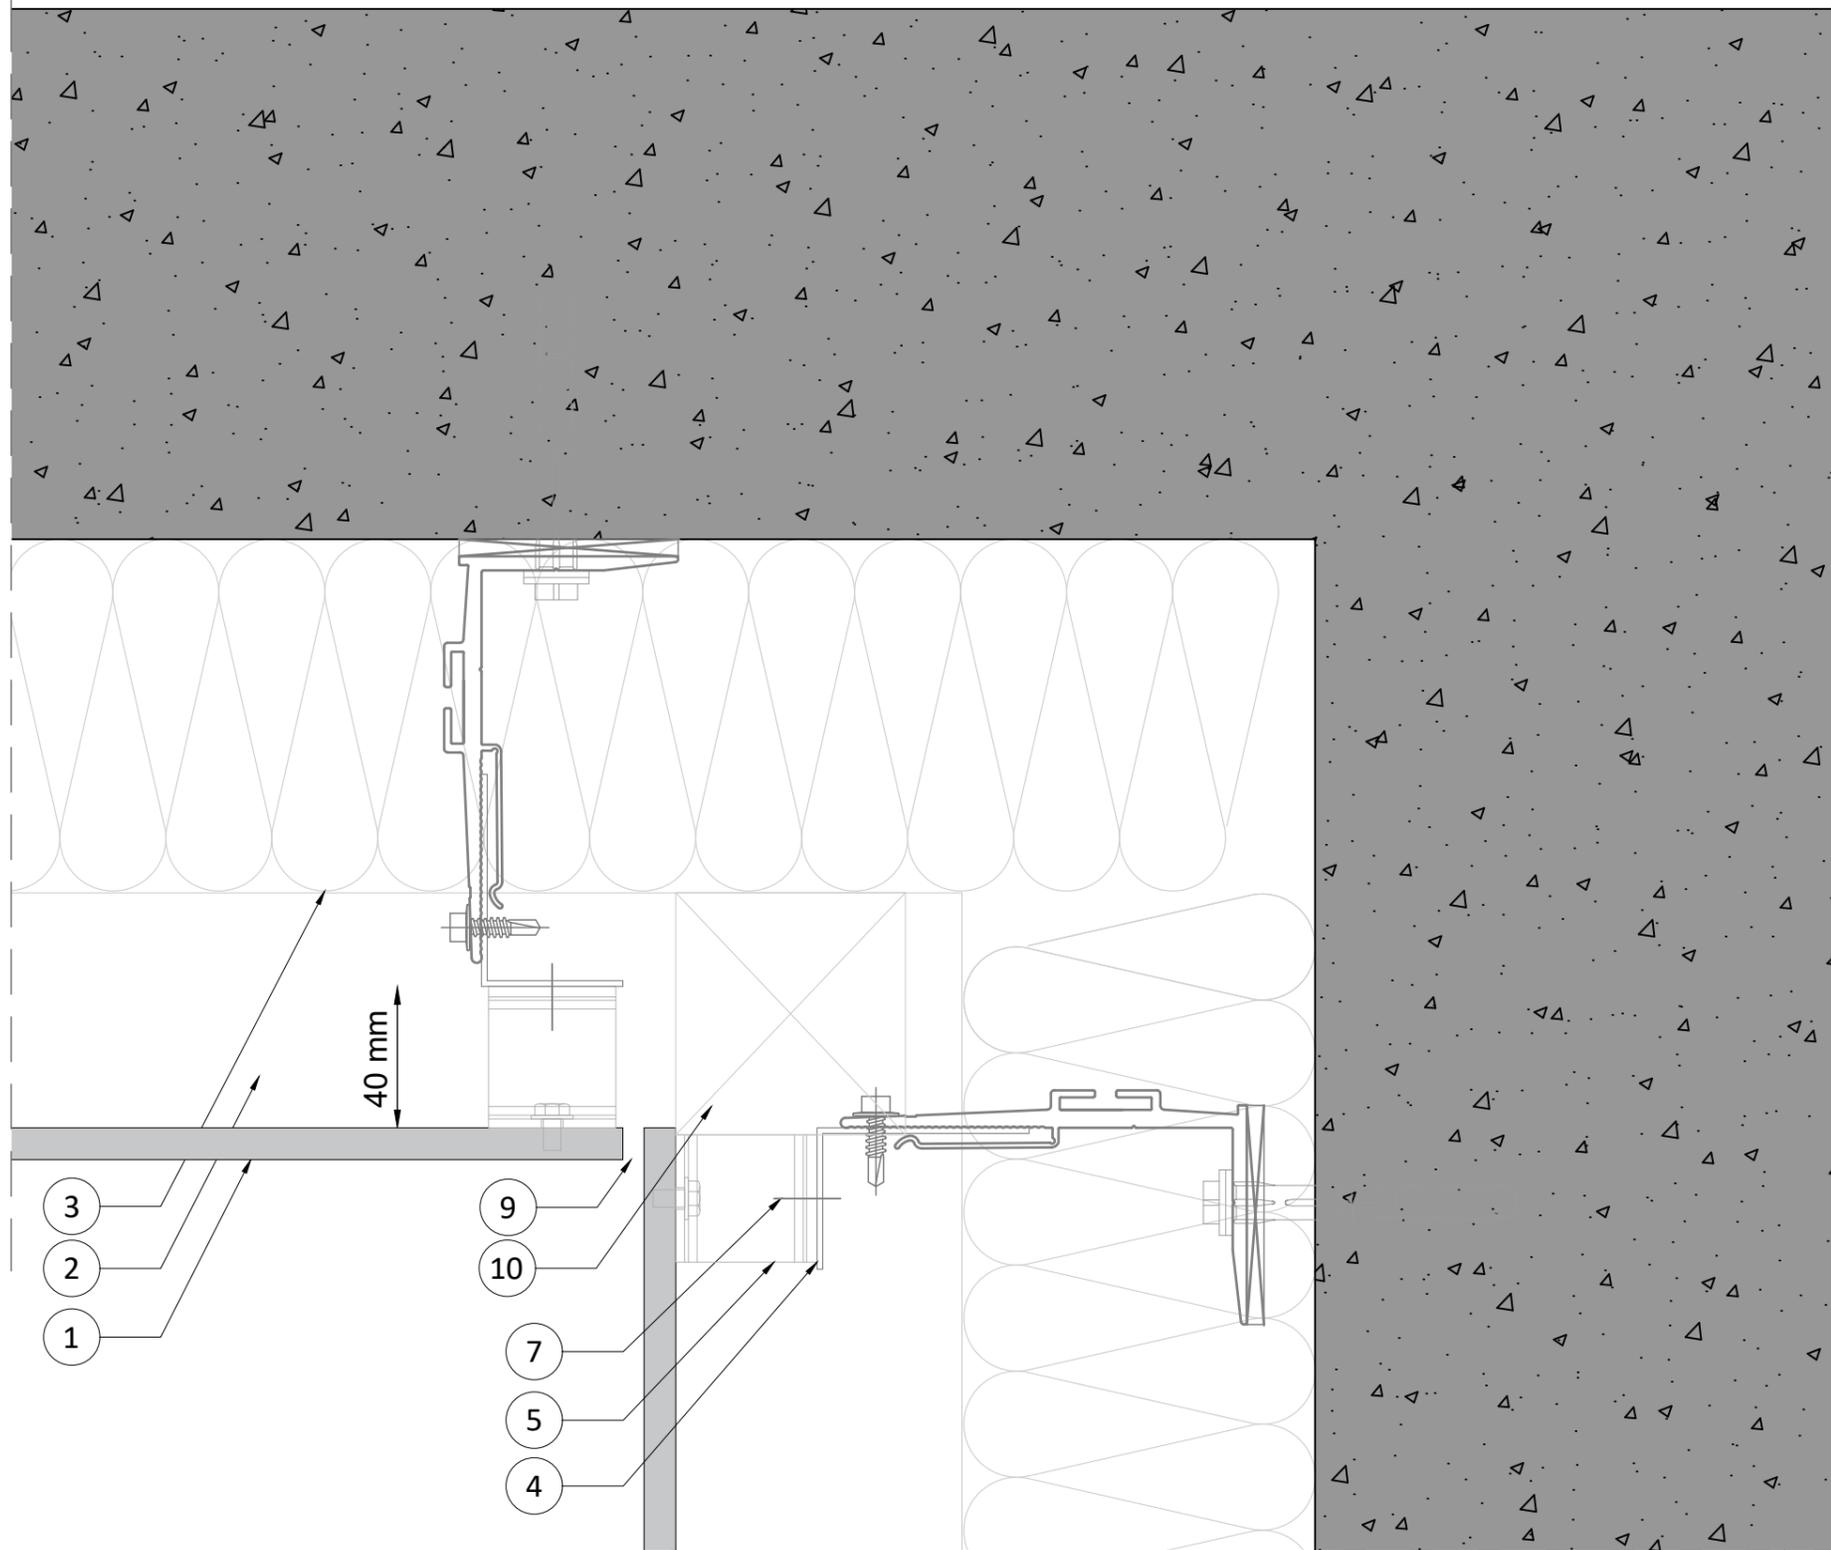

NUMBER  
**RP A2 9 PlankClip Alu**

BOARD - SUB-CONSTRUCTION  
 A2 9 mm - PlankClip on aluminium

SECTION - DETAIL  
 Horizontal section - Detail 03

DESCRIPTION  
 Internal Corner


DATE - VERSION  
 01.07.2025

SCALE - PAPER  
 Scale 1:2 on A3 print

LANGUAGE  
 All

PAGE - NUMBER  
 Page 05/10



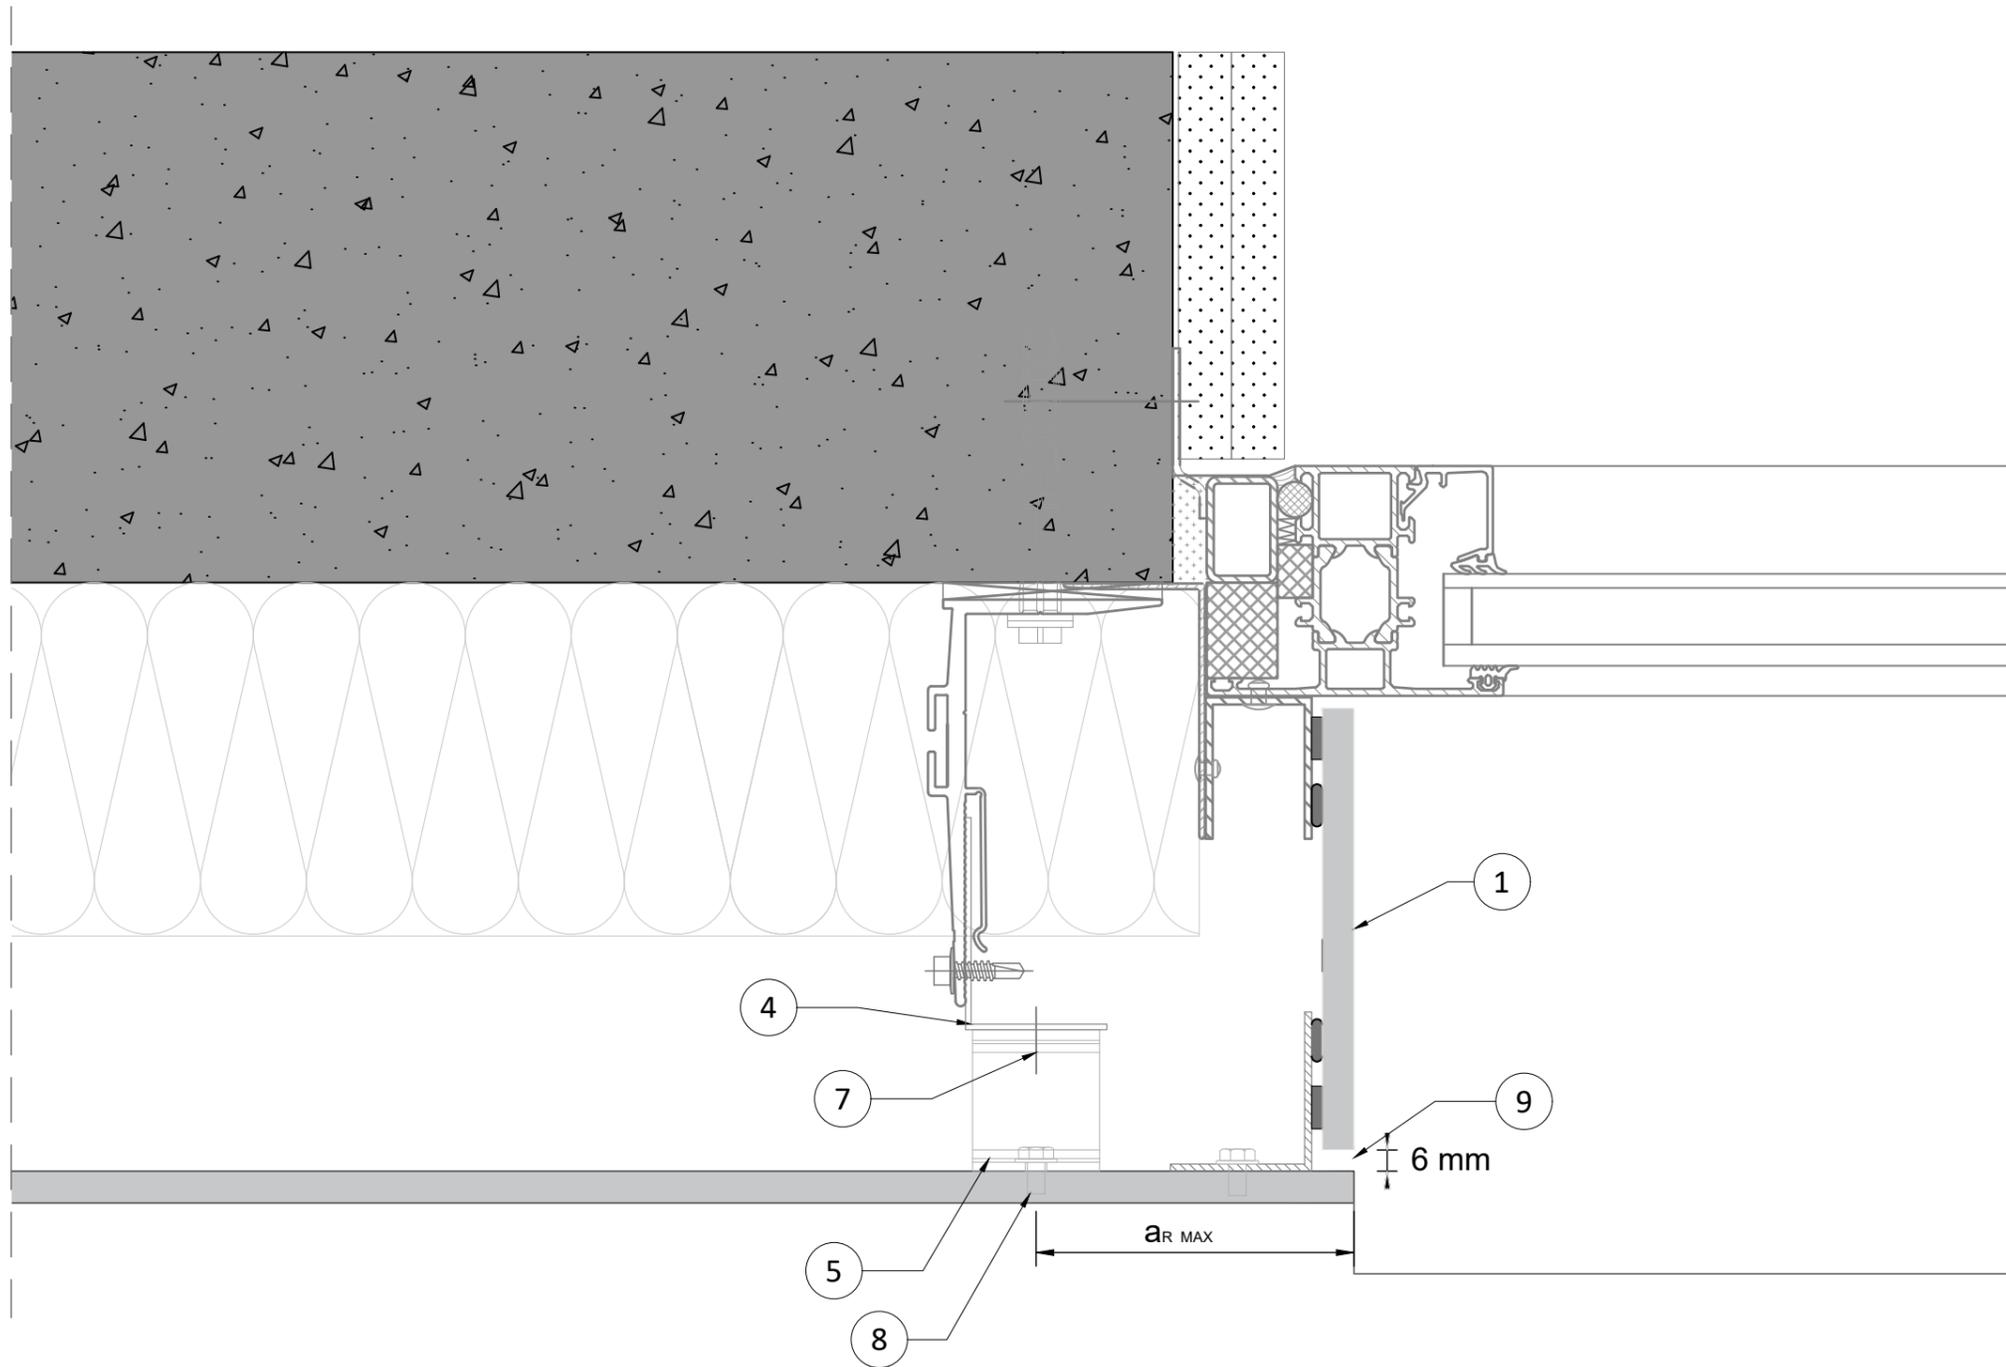


NUMBER  
**RP A2 9 PlankClip Alu**

BOARD - SUB-CONSTRUCTION  
 A2 9 mm - PlankClip on aluminium  
 SECTION - DETAIL  
 Horizontal section - Detail 04  
 DESCRIPTION  
 Window junction

DATE - VERSION  
 01.07.2025  
 SCALE - PAPER  
 Scale 1:2 on A3 print

LANGUAGE  
 All  
 PAGE - NUMBER  
 Page 06/10

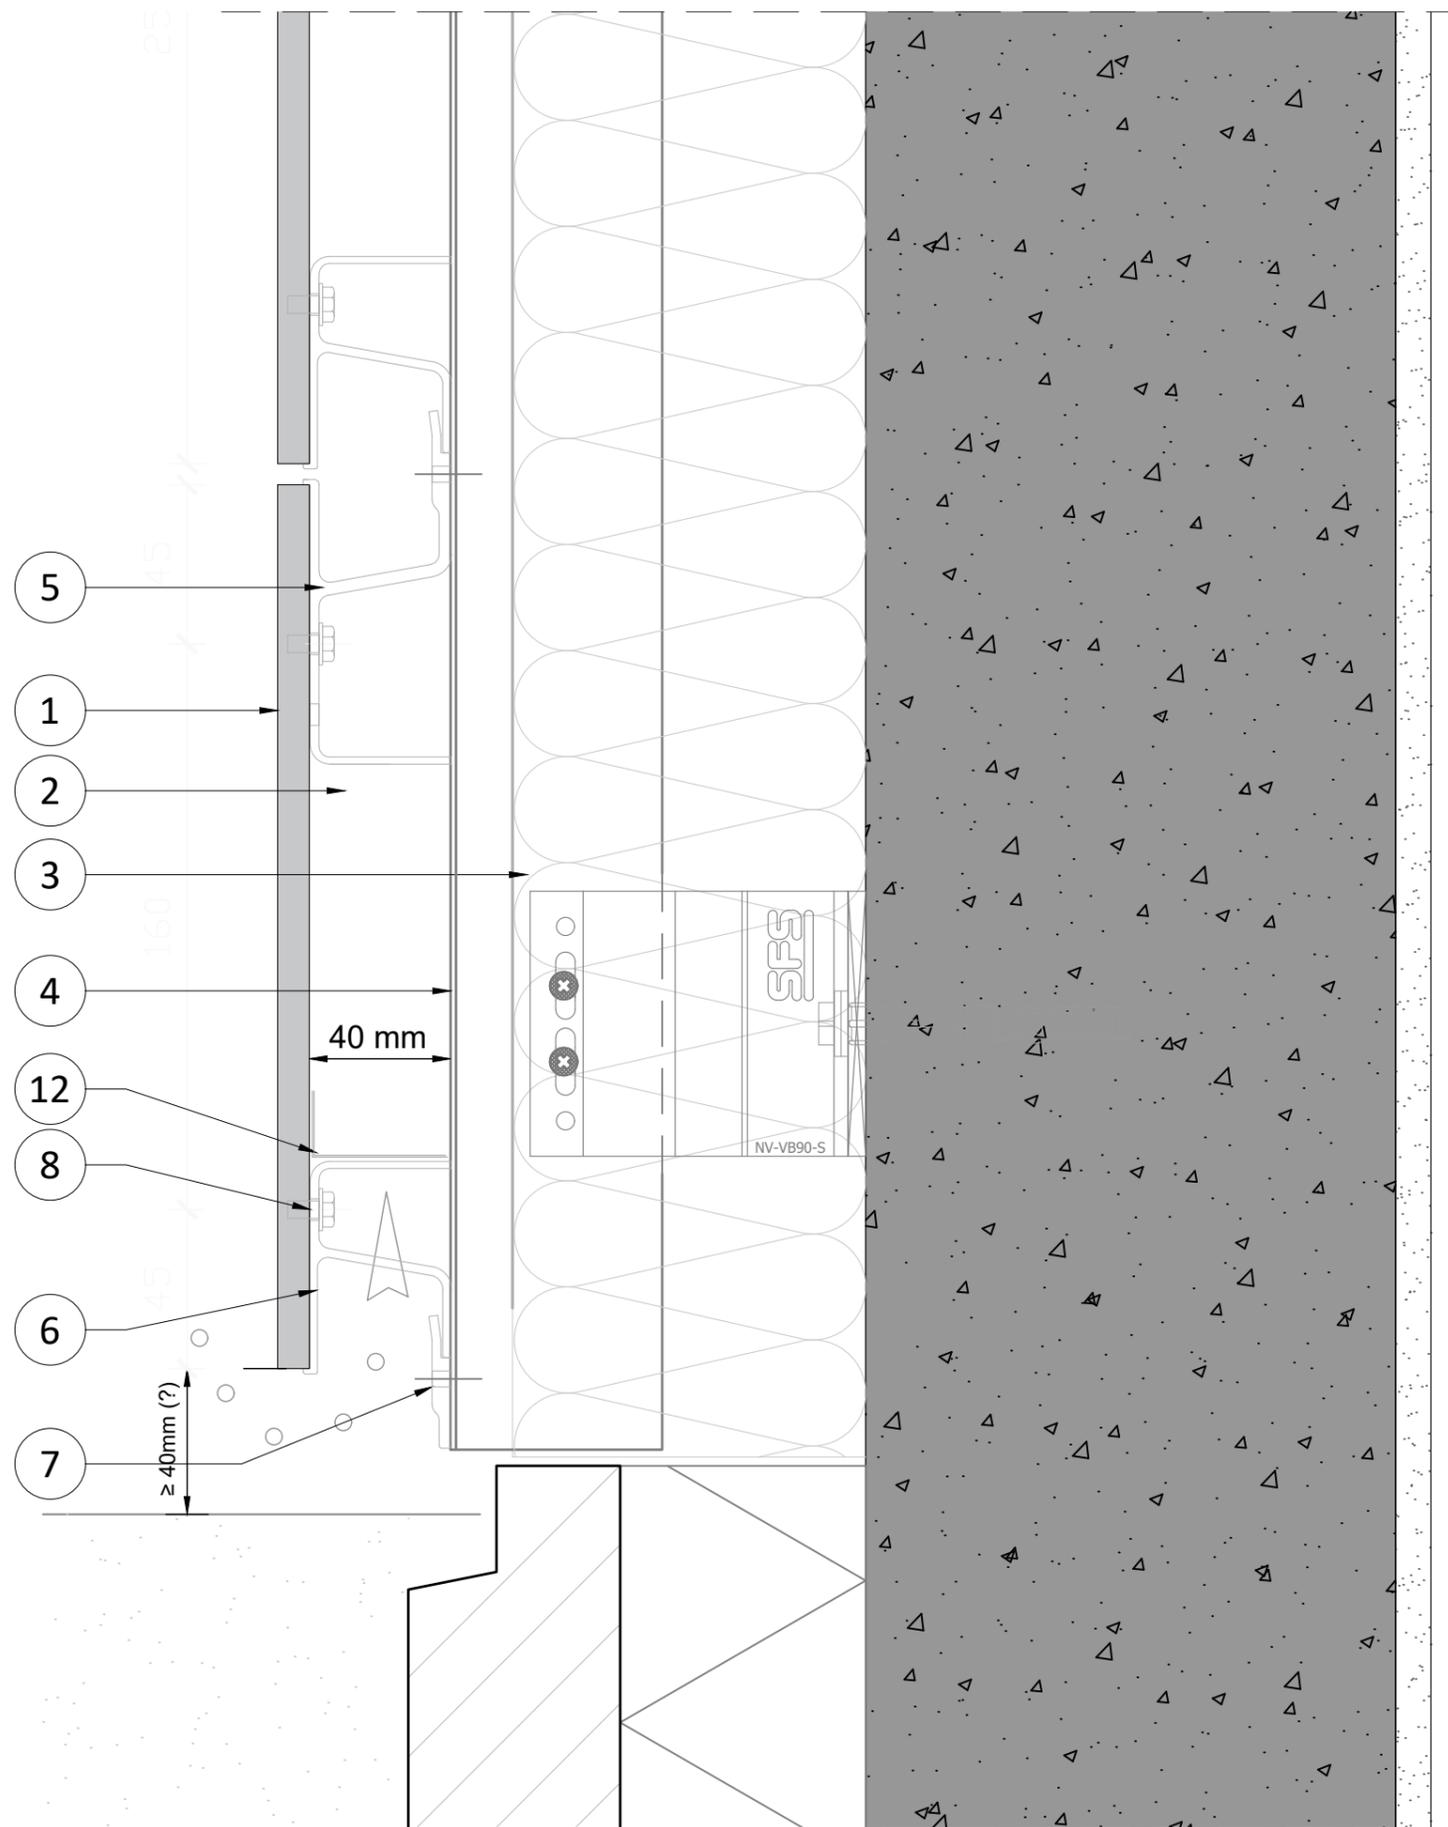


NUMBER  
**RP A2 9 PlankClip Alu**

BOARD - SUB-CONSTRUCTION  
 A2 9 mm - PlankClip on aluminium  
 SECTION - DETAIL  
 Vertical section - Detail 01  
 DESCRIPTION  
 Junction vertical joint

DATE - VERSION  
 01.07.2025  
 SCALE - PAPER  
 Scale 1:2 on A3 print

LANGUAGE  
 All  
 PAGE - NUMBER  
 Page 07/10



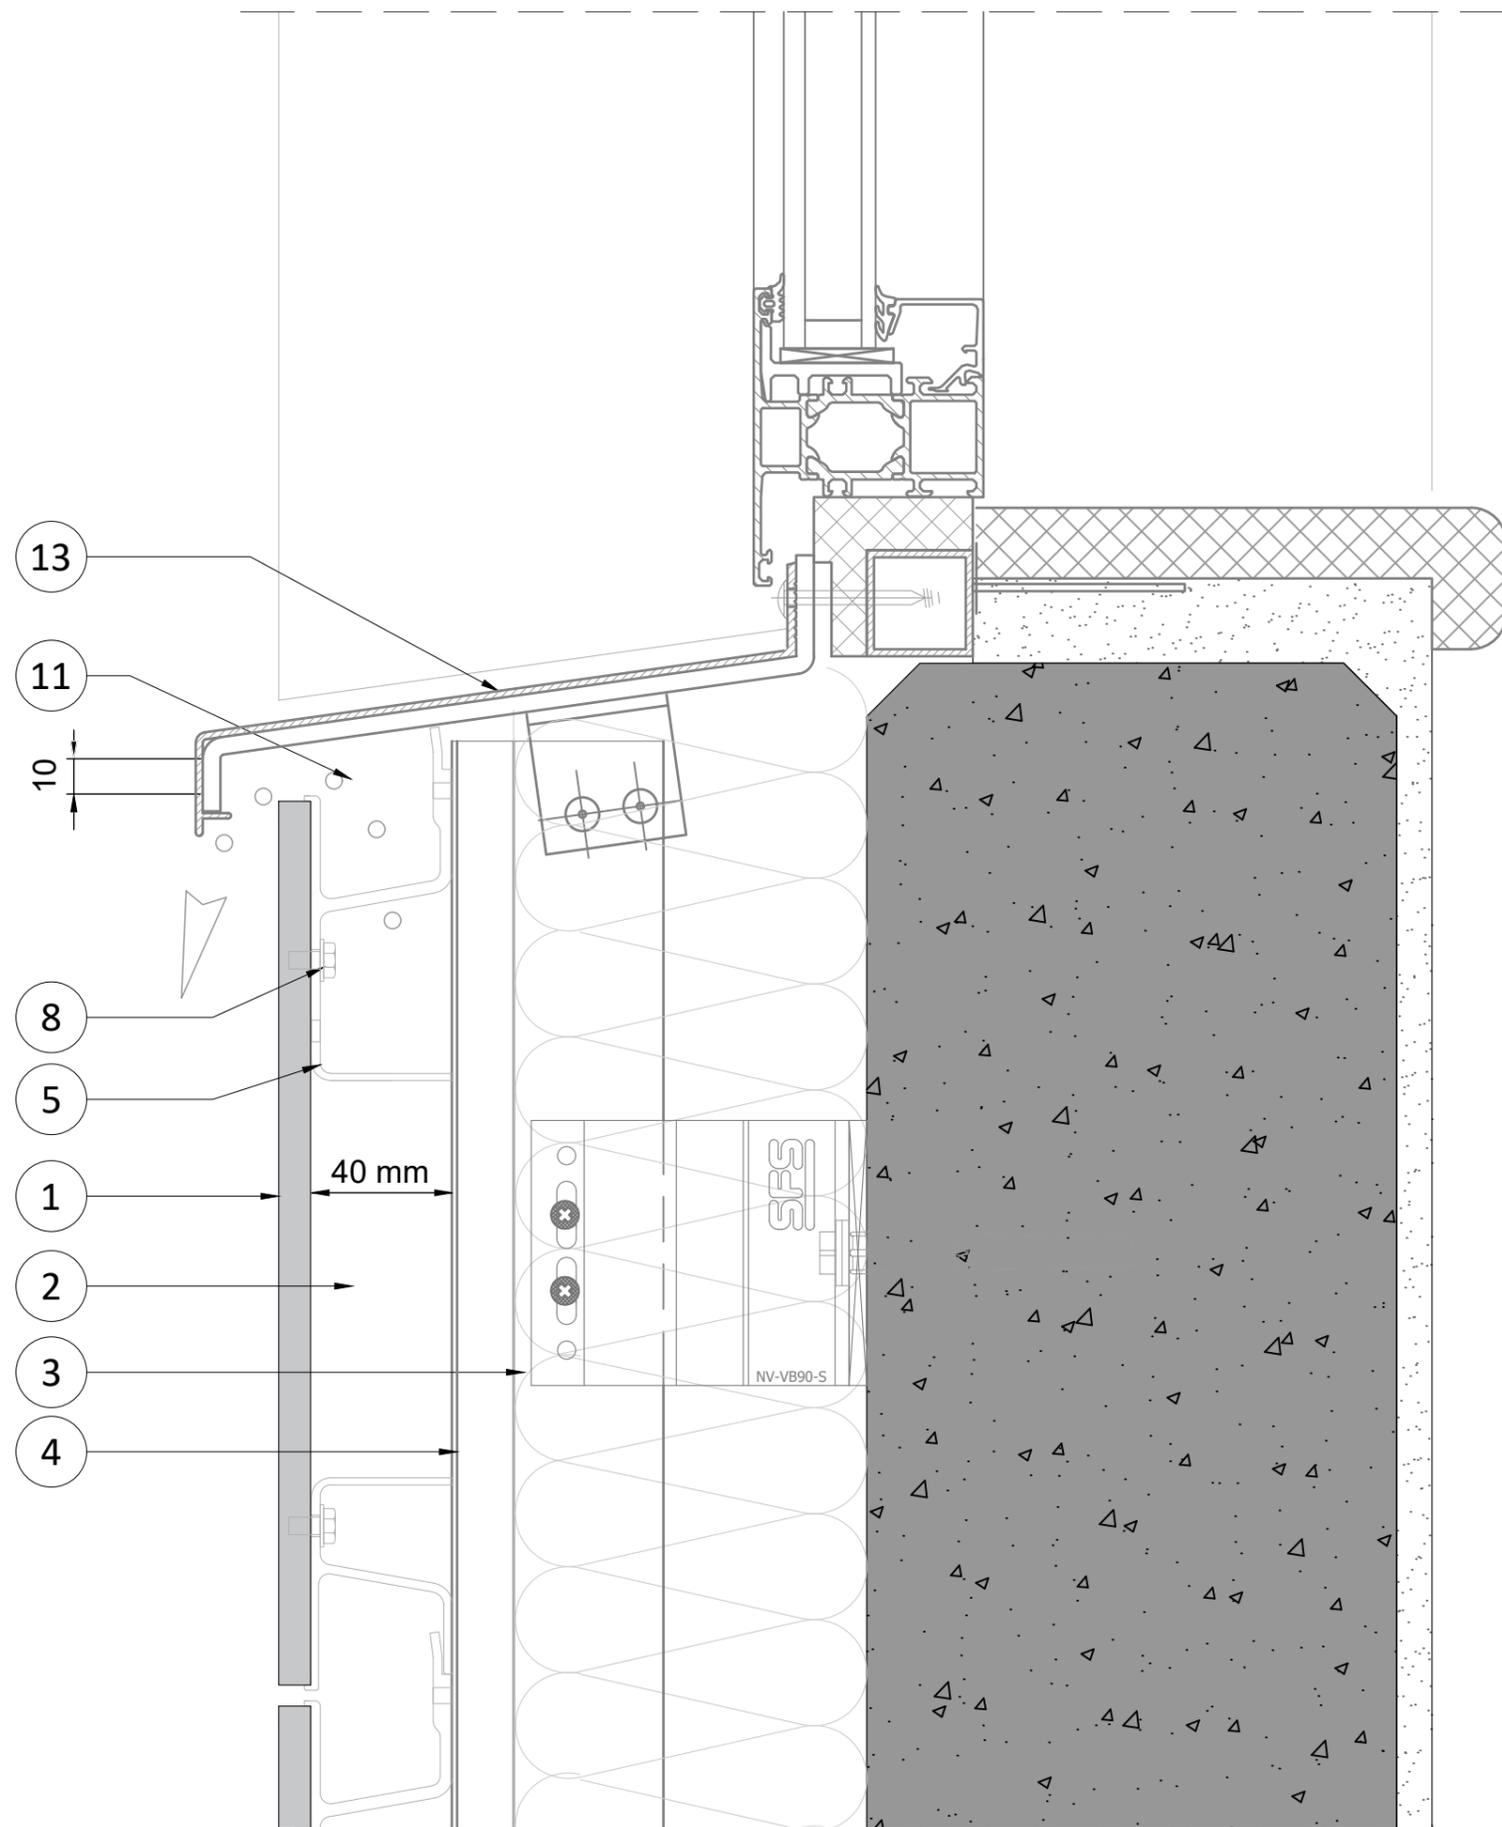


NUMBER  
**RP A2 9 PlankClip Alu**

BOARD - SUB-CONSTRUCTION  
 A2 9 mm - PlankClip on aluminium  
 SECTION - DETAIL  
 Vertical section - Detail 02  
 DESCRIPTION  
 Junction window-sill

DATE - VERSION  
 01.07.2025  
 SCALE - PAPER  
 Scale 1:2 on A3 print

LANGUAGE  
 All  
 PAGE - NUMBER  
 Page 08/10



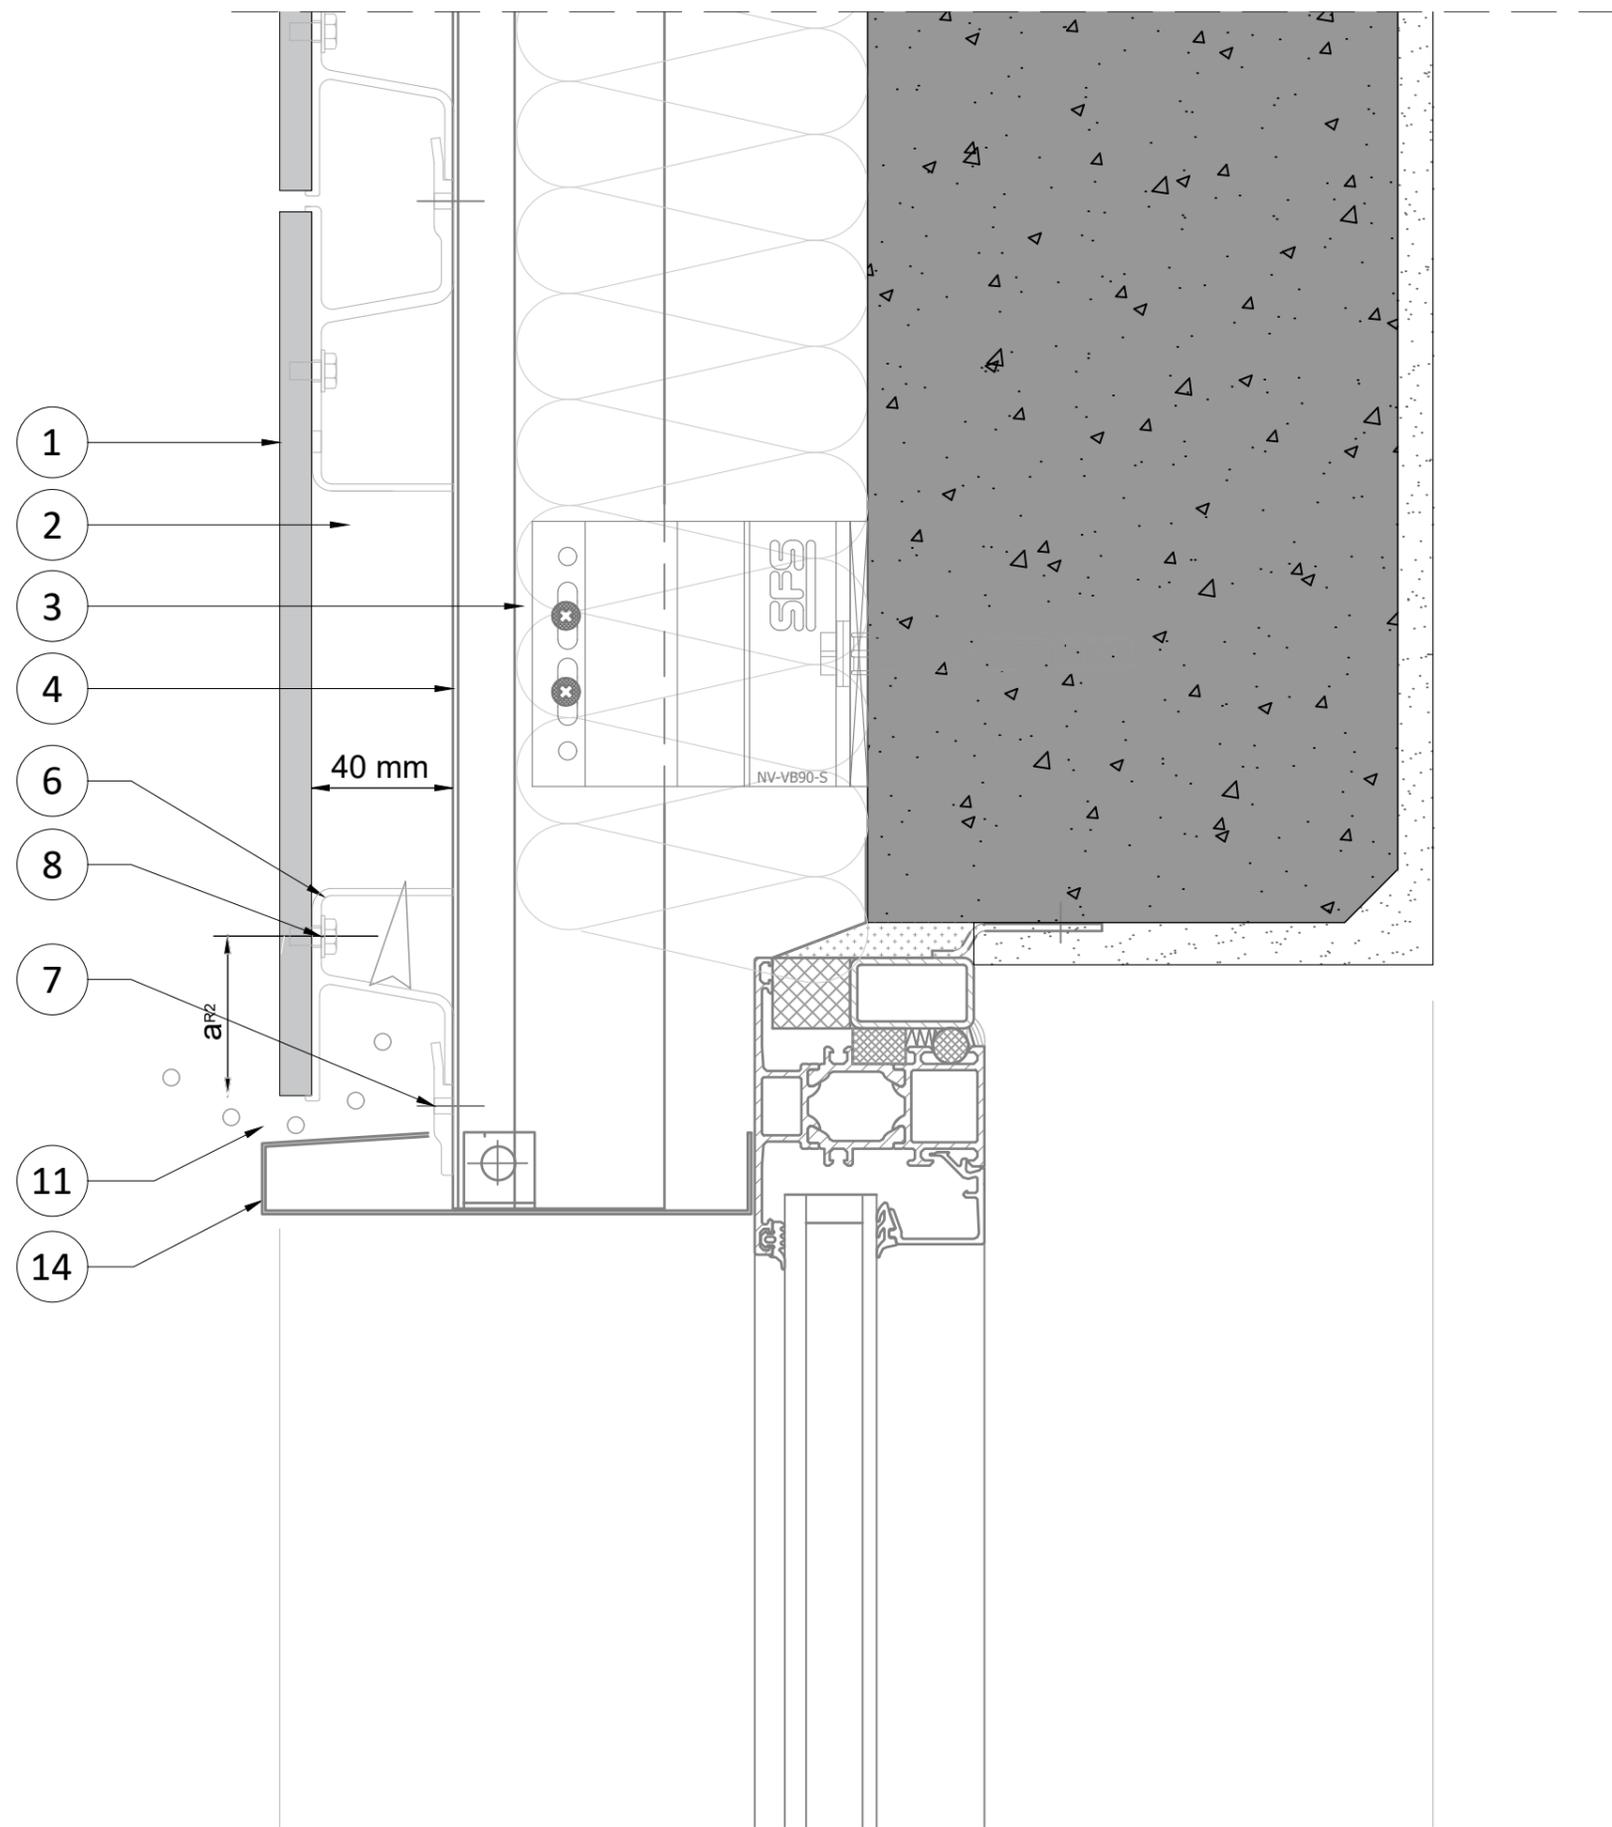

NUMBER  
**RP A2 9 PlankClip Alu**

BOARD - SUB-CONSTRUCTION  
 A2 9 mm - PlankClip on aluminium

SECTION - DETAIL  
 Vertical section - Detail 03


DESCRIPTION  
 Junction window header

DATE - VERSION  
 01.07.2025

SCALE - PAPER  
 Scale 1:2 on A3 print

LANGUAGE  
 All

PAGE - NUMBER  
 Page 09/10

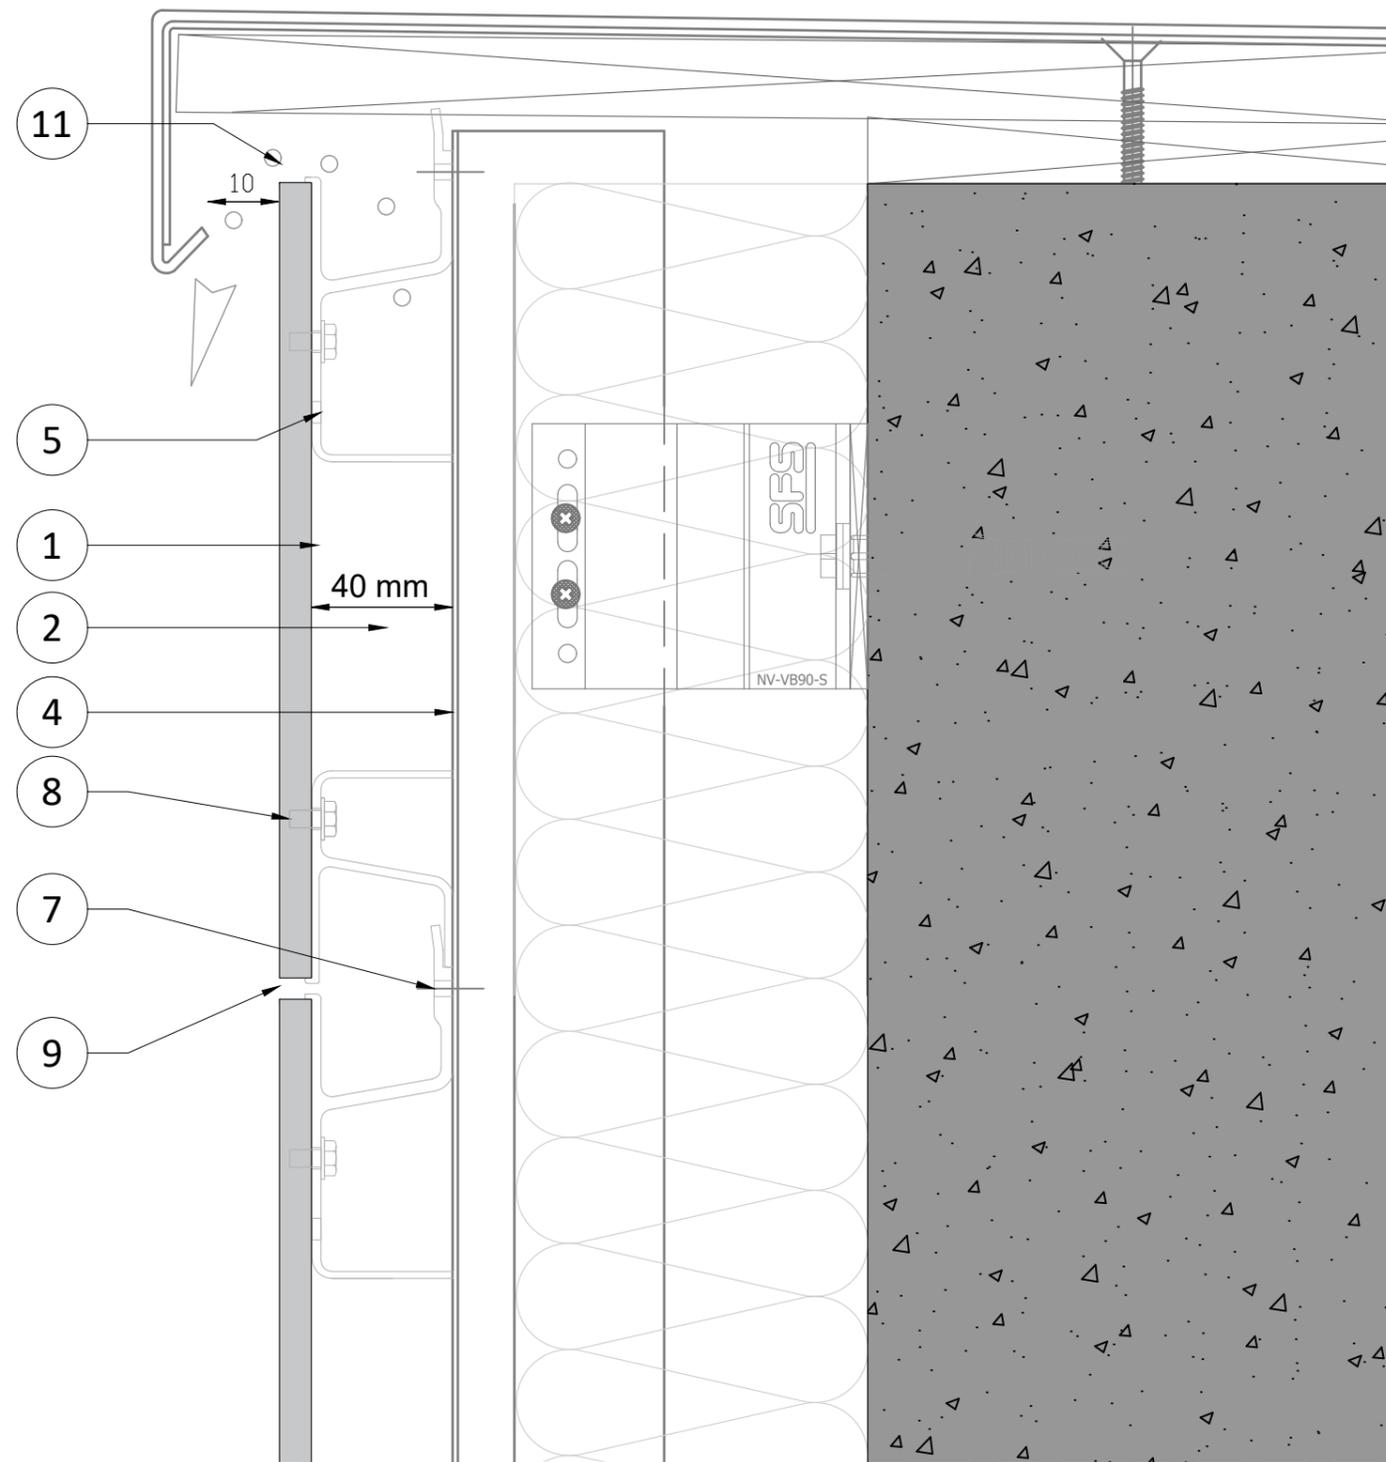

NUMBER  
**RP A2 9 PlankClip Alu**

BOARD - SUB-CONSTRUCTION  
 A2 9 mm - PlankClip on aluminium  
 SECTION - DETAIL  
 Vertical section - Detail 04  
 DESCRIPTION  
 Roof trim - parapet

DATE - VERSION  
 01.07.2025  
 SCALE - PAPER  
 Scale 1:2 on A3 print

LANGUAGE  
 All  
 PAGE - NUMBER  
 Page 10/10



	EN	NL	DE	FR	PL
1	Rockpanel A2 9 mm	Rockpanel A2 9 mm	Rockpanel A2 9 mm	Rockpanel A2 9 mm	Rockpanel A2 9 mm
2	Air cavity	Luchtspouw	Hinterlüftungsraum	Lame d'air	Szczelina wentylacja
3	Insulation (ROCKWOOL)	Steenwolisolatie (ROCKWOOL)	Dämmung (ROCKWOOL)	Isolation (ROCKWOOL)	Izolacja (ROCKWOOL)
4	Aluminium rail	Aluminium draagprofiel	Aluminium Tragprofil	Montant Aluminium	Profil aluminiowy
5	PlankClip (RCLIP)	PlankClip (RCLIP)	PlankClip (RCLIP)	PlankClip (RCLIP)	PlankClip (RCLIP)
6	PlankClip (RCLIP-SHORT)	PlankClip (RCLIP-SHORT)	PlankClip (RCLIP-SHORT)	PlankClip (RCLIP-SHORT)	PlankClip (RCLIP-SHORT)
7	SFS SDAW fastener 4.5 x 34 mm	SFS SDAW fastener 4.5 x 34 mm	SFS SDAW fastener 4.5 x 34 mm	SFS SDAW fastener 4.5 x 34 mm	SFS SDAW fastener 4.5 x 34 mm
8	SFS TU-S 6x9 mm anchor	SFS TU-S 6x9 mm anchor	SFS TU-S 6x9 mm anchor	SFS TU-S 6x9 mm anchor	SFS TU-S 6x9 mm anchor
9	Joint 6 mm	Voeg 6 mm	Fuge 6 mm	Joint 6 mm	Łączenie 6 mm
10	Cavity closure	Spouw in hoek dichtgezet	Hohlraumverschluss	Profil vertical de compartimentage	
11	Ventilation opening	Ventilatieopening	Lüftungsspalt	Vide de ventilation	Szczelina wentylacyjna
12	Ventilation profile / Anti-Insect mesh	Ventilatieprofiel (anti-insect)	Lüftungsprofil	Profil de ventilation / Grille anti-rongeur	Profil wentylacyjny / Siatka zabezpieczająca przed owadami
13	Windowsill with end dam	Vensterbank met kopschot	Fensterbank mit kopteil	Seuil alu avec larmier	Parapet okienny
14	Metal cover/flashing	Metalen zetwerk	Metallabdeckung	Solin métallique	Metalowa osłona
a <sub>R1</sub>	≥ 20 mm	≥ 20 mm	≥ 20 mm	≥ 20 mm	≥ 20 mm
a <sub>R2</sub>	≥ 50 mm	≥ 50 mm	≥ 50 mm	≥ 50 mm	≥ 50 mm

	EN	DK	NO	SE	FI
1	Rockpanel A2 9 mm	Rockpanel A2 9 mm	Rockpanel A2 9 mm	Rockpanel A2 9 mm	Rockpanel A2 9 mm
2	Air cavity	Ventilation	Luft hulrom	Luftspalt	Tuuletusväli
3	Insulation (ROCKWOOL)	Isolering (ROCKWOOL)	Isolasjon (ROCKWOOL)	Isolering (ROCKWOOL)	Eriste (ROCKWOOL)
4	Aluminium rail	Aluminium opretstående	Aluminium skinne	Aluminiumskena	Alumiiniranka
5	PlankClip (RCLIP)	PlankClip (RCLIP)	PlankClip (RCLIP)	PlankClip (RCLIP)	PlankClip (RCLIP)
6	PlankClip (RCLIP-SHORT)	PlankClip (RCLIP-SHORT)	PlankClip (RCLIP-SHORT)	PlankClip (RCLIP-SHORT)	PlankClip (RCLIP-SHORT)
7	SFS SDAW fastener 4.5 x 34 mm	SFS SDAW fastener 4.5 x 34 mm	SFS SDAW fastener 4.5 x 34 mm	SFS SDAW fastener 4.5 x 34 mm	SFS SDAW fastener 4.5 x 34 mm
8	SFS TU-S 6x9 mm anchor	SFS TU-S 6x9 mm anchor	SFS TU-S 6x9 mm anchor	SFS TU-S 6x9 mm anchor	SFS TU-S 6x9 mm anchor
9	Joint 6 mm	Samling 6 mm	Skjøtene (6 mm)	Fog 6 mm	Sauma 6 mm
10	Cavity closure	Tætningsliste	Tettelist	Stängning av hålrum	
11	Ventilation opening	Ventilation	Ventilasjonsåpning	Ventilationsöppning	Tuuletusvälin suuaukko
12	Ventilation profile / Anti-Insect mesh	Ventilations profil / Insektnet	Ventilasjonsprofil / Insektsnett	Ventilationsprofil / Insektsskydd	Tuuletusprofiili / Hyönteisverkko
13	Windowsill with end dam	Sålbænk	Vinduskarm med kant	Fönsterbleck med sidokant	Ikkunan vesipelti
14	Metal cover/flashing	Metaldæksel	Metalldeksel	Metalskydd	Pellitys
a <sub>R1</sub>	≥ 20 mm	≥ 20 mm	≥ 20 mm	≥ 20 mm	≥ 20 mm
a <sub>R2</sub>	≥ 50 mm	≥ 50 mm	≥ 50 mm	≥ 50 mm	≥ 50 mm

NUMBER

RP A2 9 PlankClip Alu

DESCRIPTION PAGE

